
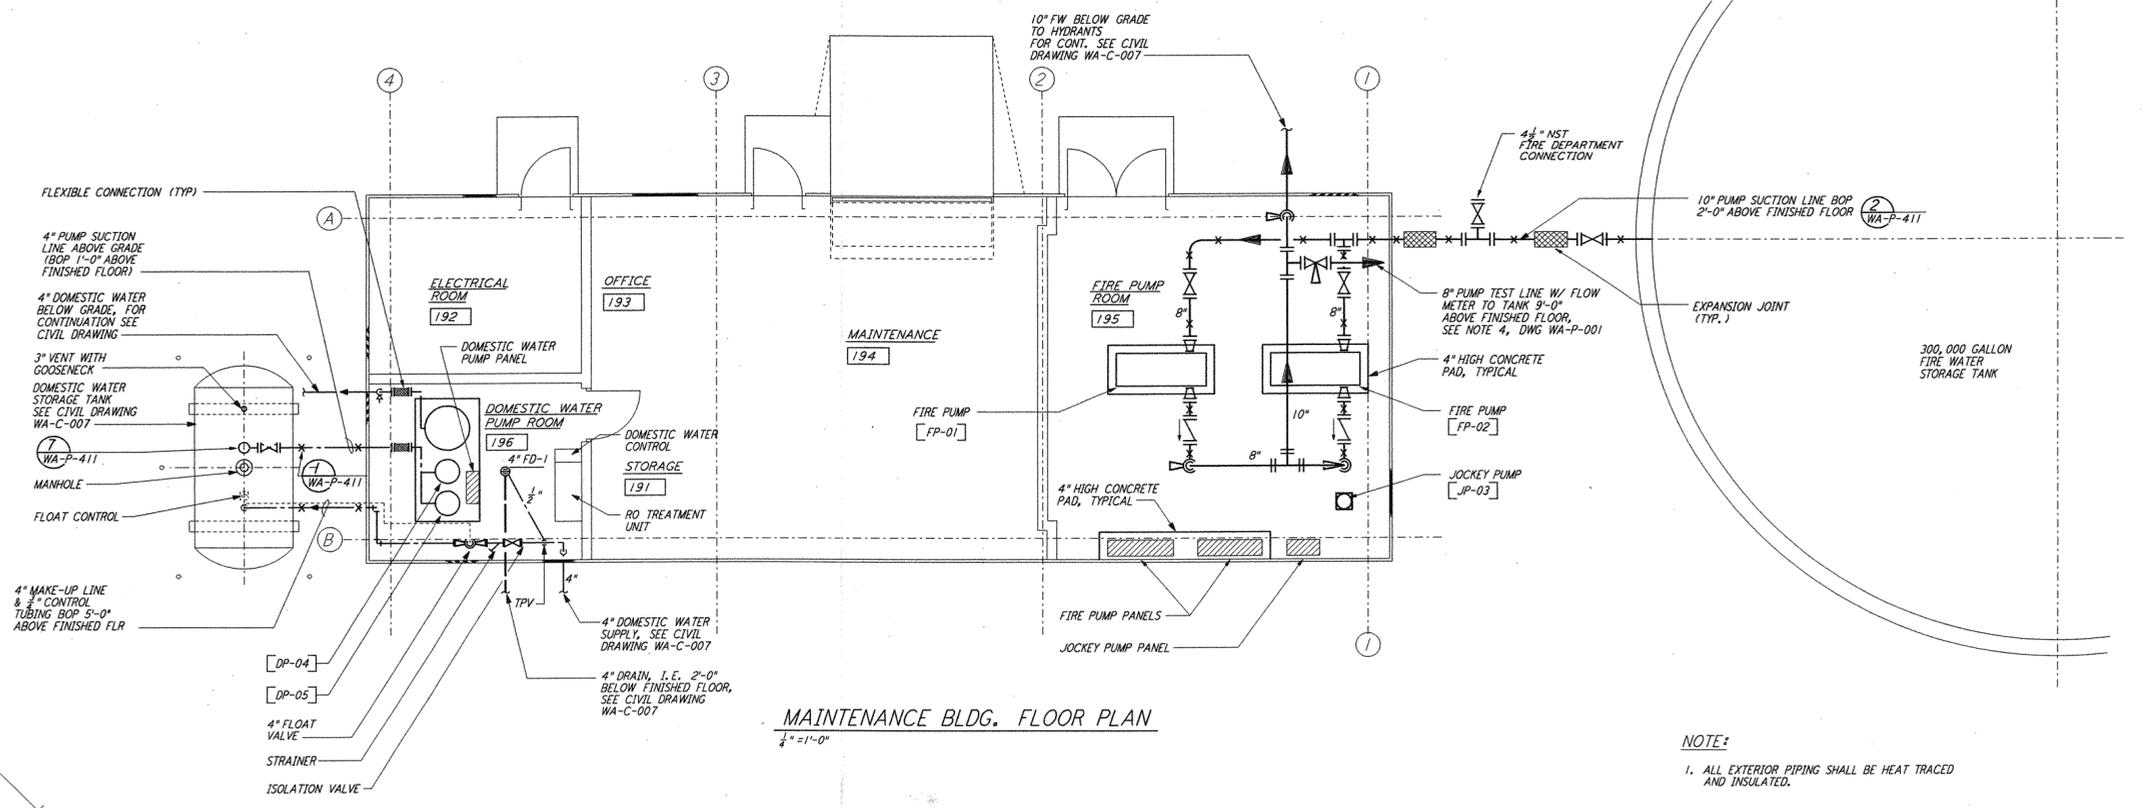


5

4


3

2

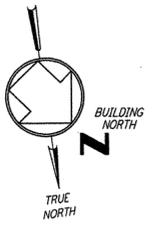


MAINTENANCE BLDG. FLOOR PLAN
 1/4" = 1'-0"

NOTE:
 1. ALL EXTERIOR PIPING SHALL BE HEAT TRACED AND INSULATED.

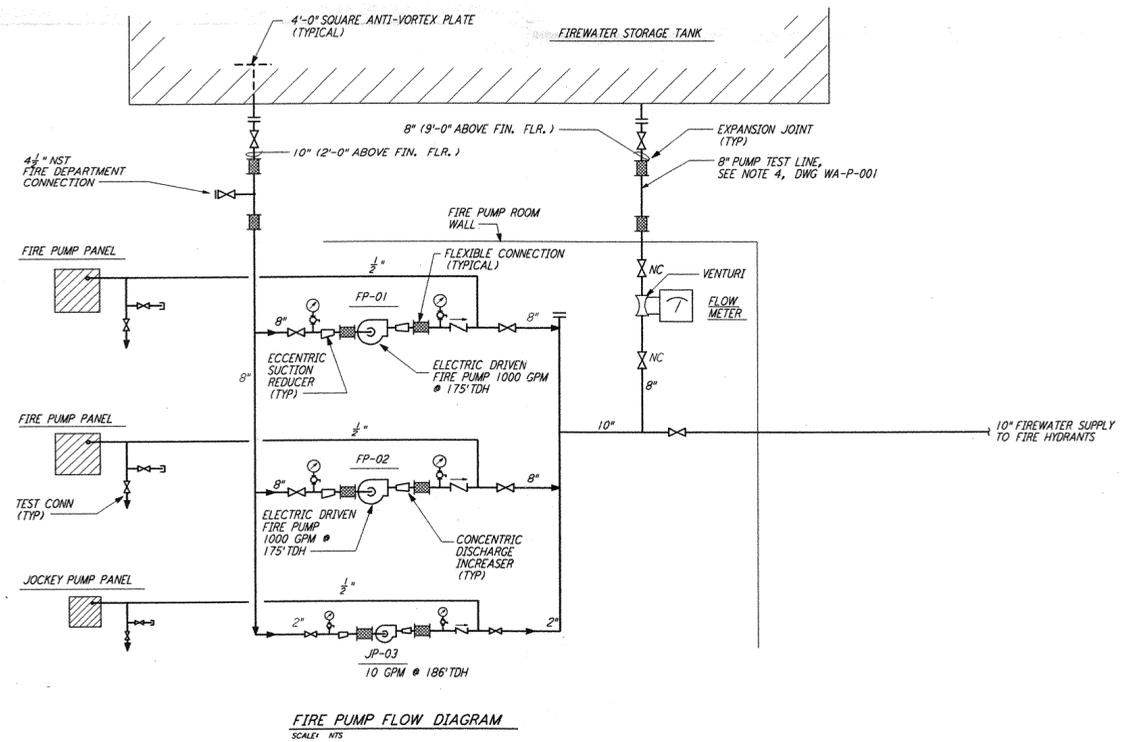

FIRE PUMP FLOW DIAGRAM
 SCALE: NTS

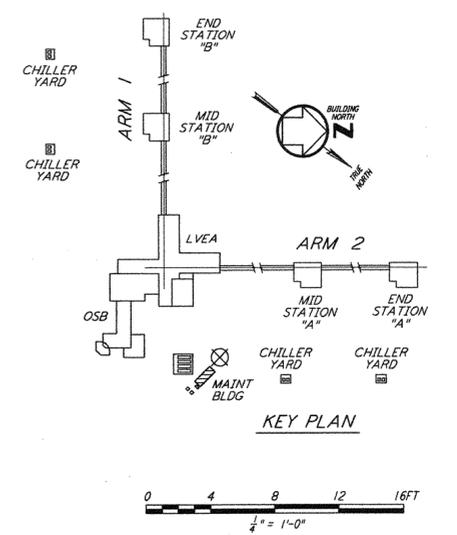

LIGO-D960442-01-O

NO.	DATE	BY	CHKD	ENGR	PROJ	ISSUED FOR AS-BUILT	DESCRIPTION
1	5-15-98	CP	AA	AA	DP		ISSUED FOR AS-BUILT

ISSUED FOR CONSTRUCTION
 DRAWN: DG 6-24-96
 CHECKED: WR 7/19/96
 ENGINEER: MN 7/19/96
 PROJ: MDW 7/19/96

AS-BUILT DRAWINGS

PARSONS
 100 WEST WALNUT STREET
 PASADENA, CALIFORNIA

LIGO
 CALIFORNIA INSTITUTE OF TECHNOLOGY
 MASSACHUSETTS INSTITUTE OF TECHNOLOGY

LASER INTERFEROMETER
 GRAVITATIONAL-WAVE OBSERVATORY
 SITE NO. 1 - HANFORD, WASHINGTON

TITLE: PLUMBING CORNER STATION MAINTENANCE BUILDING FLOOR PLAN & FLOW DIAGRAM
 SCALE: AS NOTED
 CONTRACT NUMBER: PP150969
 PROJECT NUMBER: 8094
 SHEET NUMBER: WA-P-113

5

4

3

2

A

B

C

D

E

This document and the design it covers are the property of PARSONS. They are loaned only with the borrower's expressed written agreement that they will not be reproduced, copied, loaned, exhibited, or used in any other way, except by written consent from PARSONS to the borrower.

This document and the design it covers are the property of PARSONS. They are loaned only with the borrower's expressed written agreement that they will not be reproduced, copied, loaned, exhibited, or used in any other way, except by written consent from PARSONS to the borrower.

Tue Jun 02 17:25:45 1998 C:\PLOT\G0E133\9802.DCF 52085 K:\V2682\m113a.prf LIGOWAF3.BOR